


	2017-10-02 BLDG PERMIT COMMENTS 🤻				2017-04-03 GMP	2017-05-22 PERMIT SET	2017-07-19 FIRE MARSHAL COMMENTS	2017-07-25 ADA COMMENTS / COORDIN	2017-07-25 BUILDING PERMIT	2017-10-02 BLDG PERMIT COMMENTS
	, 20,	β	Sheet Number	Sheet Name	20,	20,	20,	20,	20,	20,
T			P1-24	BUILDING 2000 PLAN PROJECT LEVEL 5	•	•			•	
			P1-25 P1-31	BUILDING 2000 PLAN PROJECT LEVEL 6 BUILDING 3000 PLAN - PROJECT LEVEL 2	•	•			•	
			P1-32 P1-33	BUILDING 3000 PLAN - PROJECT LEVEL 3 BUILDING 3000 PLAN - PROJECT LEVEL 4	•	•			•	
	•		P1-34	BUILDING 3000 PLAN - PROJECT LEVEL 5	•	•			•	
			P1-35 P1-36	BUILDING 3000 PLAN - PROJECT LEVEL 6 BUILDING 3000 PLAN - PROJECT LEVEL 7	•	•			•	
			P1-41 P1-42	BUILDING 4000 PLAN - PROJECT LEVEL 4 BUILDING 4000 PLAN - PROJECT LEVEL 5	•	•			•	
			P1-43	BUILDING 4000 PLAN - PROJECT LEVEL 6	•	•			•	
			P1-44 P1-45	BUILDING 4000 PLAN - PROJECT LEVEL 7 BUILDING 4000 PLAN - PROJECT LEVEL 8	•	•			•	
			P1-46 P2-01	BUILDING 4000 PLAN - PROJECT LEVEL 9 ROOF PLAN PLUMBING	•	•			•	
	•		P2-01 P2-02	ROOF PLAN PLUMBING ROOF PLAN PLUMBING	•	•			•	•
			P2-03 P2-04	ROOF PLAN PLUMBING ROOF PLAN PLUMBING	•	•			•	•
			P2-05	ROOF PLAN PLUMBING	•	•			•	•
	•		P3-01 P3-02	UNIT PLANS - PLUMBING UNIT PLANS - PLUMBING	•	•			•	
			P3-03 P3-04	UNIT PLANS - PLUMBING UNIT PLANS - PLUMBING	•	•			•	
			P3-04 P3-05	UNIT PLANS - PLUMBING	•	•			•	
			P3-06 P3-07	UNIT PLANS - PLUMBING UNIT PLANS - PLUMBING	•	•			•	
			P3-08	UNIT PLANS - PLUMBING	•	•			•	
			P3-09 P3-10	UNIT PLANS - PLUMBING UNIT PLANS - PLUMBING	•	•			•	
			P3-11 P3-12	UNIT PLANS - PLUMBING UNIT PLANS - PLUMBING	•	•			•	
			P3-13	UNIT PLANS - PLUMBING	•	•			•	
			P3-14 P3-15	UNIT PLANS - PLUMBING UNIT PLANS - PLUMBING	•	•			•	
			P3-16 P3-17	UNIT PLANS - PLUMBING UNIT PLANS - PLUMBING	•	•			•	
			P3-18	UNIT PLANS - PLUMBING	•	•			•	
			P3-19 P3-20	UNIT PLANS - PLUMBING UNIT PLANS - PLUMBING	•	•			•	•
	•		P3-21 P6-01	UNIT PLANS - PLUMBING AMENITY PLANS CLUBROOM & LEASING		•			•	
			P6-02	AMENITY PLANS DOG SPA & SKY LOUNGE	•	•			•	
	•		PP1-01 PP1-02	PARKING DECK PLAN - PROJECT LEVEL 2 PARKING DECK PLAN - PROJECT LEVEL 3	•	•			•	
	•		PP1-03	PARKING DECK PLAN - PROJECT LEVEL 4	•	•			•	
			PP1-04 PP1-05	PARKING DECK PLAN - PROJECT LEVEL 5 PARKING DECK PLAN - PROJECT LEVEL 6	•	•			•	
	•		PP1-06	PARKING DECK PLAN - PROJECT LEVEL 7	•	•			•	
			07 MECHANICAL	CENEDAL NOTES AND SCHEDULES	_					
			M0-01 M0-02	GENERAL NOTES AND SCHEDULES DETAILS - HVAC	•	•	•		•	
			M0-03 M0-04	DETAILS - HVAC DETAILS - HVAC	•	•	•		•	
	•		M1-11A	BUILDING 1000A - PROJECT LEVEL 1	•	•			•	
			M1-11B M1-12A	BUILDING 1000B - PROJECT LEVEL 1 BUILDING 1000A - PROJECT LEVEL 2	•	•	•		•	
			M1-12B M1-13A	BUILDING 1000B - PROJECT LEVEL 2 BUILDING 1000A - PROJECT LEVEL 3	•	•	•		•	
			M1-13B	BUILDING 1000B - PROJECT LEVEL 3	•	•			•	
			M1-14A M1-14B	BUILDING 1000A - PROJECT LEVEL 4 BUILDING 1000B - PROJECT LEVEL 4	•	•			•	
	•		M1-15A M1-15B	BUILDING 1000A - PROJECT LEVEL 5 BUILDING 1000B - PROJECT LEVEL 5	•	•			•	
			M1-16A	BUILDING 1000A - PROJECT LEVEL 6	•	•			•	
			M1-16B M1-22	BUILDING 1000B - PROJECT LEVEL 6 BUILDING 2000 - PROJECT LEVEL 3	•	•	•		•	
	•		M1-23 M1-24	BUILDING 2000 - PROJECT LEVEL 4 BUILDING 2000 - PROJECT LEVEL 5	•	•			•	
			M1-25	BUILDING 2000 - PROJECT LEVEL 5	•	•			•	
			M1-26 M1-32	BUILDING 2000 - PROJECT LEVEL 6 BUILDING 3000 - PROJECT LEVEL 2	•	•			•	
	•		M1-33 M1-34	BUILDING 3000 - PROJECT LEVEL 3 BUILDING 3000 - PROJECT LEVEL 4	•	•			•	•
			M1-35	BUILDING 3000 - PROJECT LEVEL 5	•	•			•	
			M1-36 M1-37	BUILDING 3000 - PROJECT LEVEL 6 BUILDING 3000 - PROJECT LEVEL 7	•	•			•	
			M1-38 M1-44	BUILDING 3000 - PROJECT LEVEL 8 BUILDING 4000 - PROJECT LEVEL 4	•	•			•	
			M1-45	BUILDING 4000 - PROJECT LEVEL 4 BUILDING 4000 - PROJECT LEVEL 5	•	•			•	
1			M1-46 M1-47	BUILDING 4000 - PROJECT LEVEL 6 BUILDING 4000 - PROJECT LEVEL 7	•	•			•	
Т			M1-48 M1-49	BUILDING 4000 - PROJECT LEVEL 8 BUILDING 4000 - PROJECT LEVEL 9	•	•			•	
+			M2-00	OVERALL ROOF PLAN	•	•			•	
ľ			M3-01 M3-02	ENLARGED UNIT PLANS - HVAC ENLARGED UNIT PLANS - HVAC	•	•			•	_
ļ			M3-03	ENLARGED UNIT PLANS - HVAC	•	•			•	
l			M3-04 M6-01	ENLARGED UNIT PLANS - HVAC AMENITY PLAN LEVEL 1 - HVAC	•	•	•	•	•	
f			M6-02 M6-03	AMENITY PLAN LEVEL 2 - HVAC DOG WASH AND SKY LOUNGE PLANS - HVAC	•	•	•		•	
ļ			MP1-12	PARKING PLAN - LEVEL 2 - HVAC	•	•	•		•	
1			MP1-13 MP1-14	PARKING PLAN - LEVEL 3 TO 6 - HVAC PARKING ROOF PLAN - HVAC	•	•	•		•	
ſ										

SHEET INDEX II

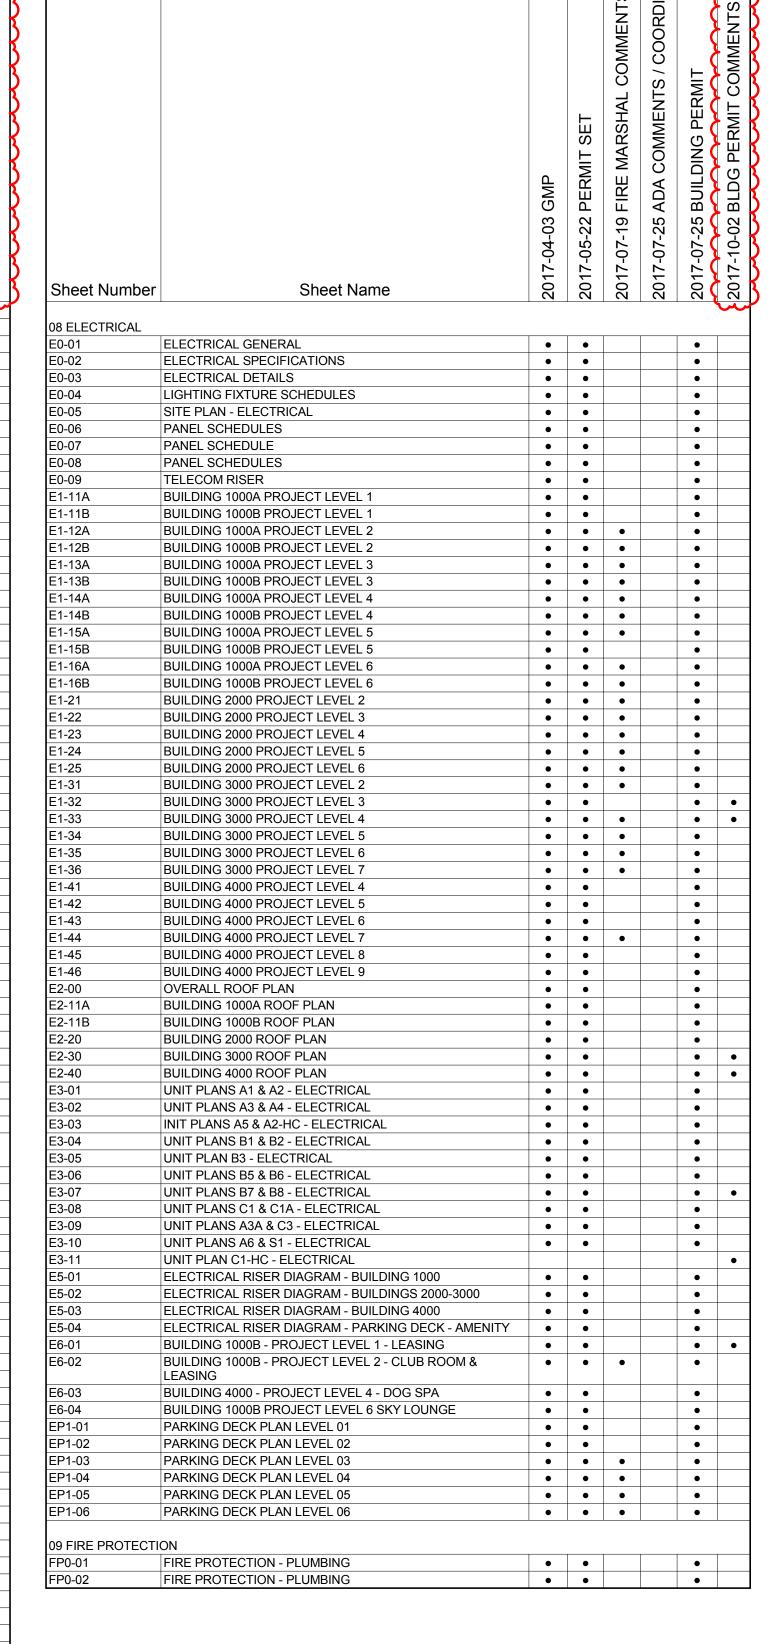

SHEET INDEX II



PARTNERSHIP, LLC A MULTI-DISCIPLINARY DESIGN FIRM

SOUTH TERRACES 115 PERIMETER CENTER PLACE, SUITE 950 ATLANTA, GEORGIA 30346 TELEPHONE: 770 396 7248 FAX: 770 396 2945

WWW.THEPRESTONPARTNERSHIP.COM CONSULTANT



RESERVE AT THE BALLPARK, PHASE II, AKA REVEL AT THE BALLPARK 2885 CRESCENT PKWY SMYRNA, GA 30080



ATLANTIC REALTY **PARTNERS**

3438 PEACHTREE ROAD **SUITE 1425** ATLANTA, GA 30326

ISSUES & 4 - REVISIONS ____ GMP 04/03/2017 PERMIT SET 05/22/2017 3 BUILDING PERMIT 07/25/2017 5 BUILDING PERMIT 10/02/2017 COMMENTS / COORDINATION

05/22/2017

DRAWING INDEX II

© 2017 The Preston Partnership, LL0